

JICA Supported Projects and Road Map of Sri Lanka



Improvements to Jaffna Teaching Hospital
Scheme : Grant
Improving facilities and equipment and also providing training programmes to maintain the equipment at the Jaffna Teaching Hospital.



Development Planning for the Rapid Promotion of Reconstruction and Development in the Jaffna District
Scheme : Technical Cooperation
Assists conflict-affected communities in Jaffna to rebuild socio-economic activities by formulating a regional development plan and strengthening community based organizations.



Vavuniya-Kilinochchi Power Transmission Line
Scheme : Loan
Laying of 73km of the 132kv double circuit three phase transmission line from Vavuniya to Kilinochchi, construction of a new 132/33 kv grid-substation in Kilinochchi and the expansion of the existing grid-substation in Vavuniya.



Tsunami-Affected Area Recovery and Takeoff Project
Supporting the restoration of small scale infrastructure projects such as water supply, roads, irrigation, electricity and social services in tsunami-affected coastal areas in Ampara, Batticaloa, Galle, Hambantota, Jaffna, Matara, Mullaitivu and Trincomalee districts.



Agricultural and Rural Development for Rehabilitation and Reconstruction through Community Approach in Trincomalee
Scheme : Technical Cooperation
Establishing an agricultural and rural development model based on community action plans to rehabilitate and reconstruct Trincomalee.



Improvements to Sigiriya Museum
Scheme : Loan, Grant and Technical Cooperation
Construction of the museum, infrastructural improvements and installation of interpretative display and other equipment at the museum and provision of Japanese expertise and training programmes for staff.



Pro Poor Economic Advancement and Community Enhancement (PEACE) in Eastern region
Scheme :



Construction of the New Highway Bridge at Manampitiya
Scheme : Grant
Construction of a 302 metre long bridge across the Maheli river.



Mahaweli Development Projects (II), Mahaweli System B Development, Mahaweli System C Upgrading Projects
Schemes : Loan, Grant
Construction of irrigation facilities and provision of assistance to improve living standards of resettled communities and farming activities in order to sustainably develop the agricultural sector.



Project for Reconstruction of five bridges in the Eastern Province
Scheme : Grant
Reconstruction of bridges between Padiyathalawa and Eruva on the A5 and the Panchankery bridge and causeway on the A15.



Pro-Poor Eastern Infrastructure Development Project
Schemes : Loan
Reconstruction of 100km of A15 and A4 and construction of the new Kallady bridge.



Long Term Expert on Rural Development
Technical Cooperation
Supporting resettled population to improve their livelihood in the emerging region.



Tourism Resources Improvement Projects
Scheme : Loan
Improving safe and easy access to world heritage sites and tourist destinations in Sri Lanka.




Road Network Improvement Project
Schemes : Loan
Construction of the longest tunnel, which is 210m, from Nawalapitiya to Nuwara Eliya.



Samanalawewa Hydroelectric Power (H) and Rehabilitation Projects
Schemes : Loan
First power plant in the country to obtain ISO 9000 and 14001.



Projects to Upgrade and Extend Walawe Left Bank Irrigation and the Improvement of Rural Infrastructure in the Area
Schemes : Loan
Contributed to the diversification, stabilization and augmentation of agricultural production in rural areas.

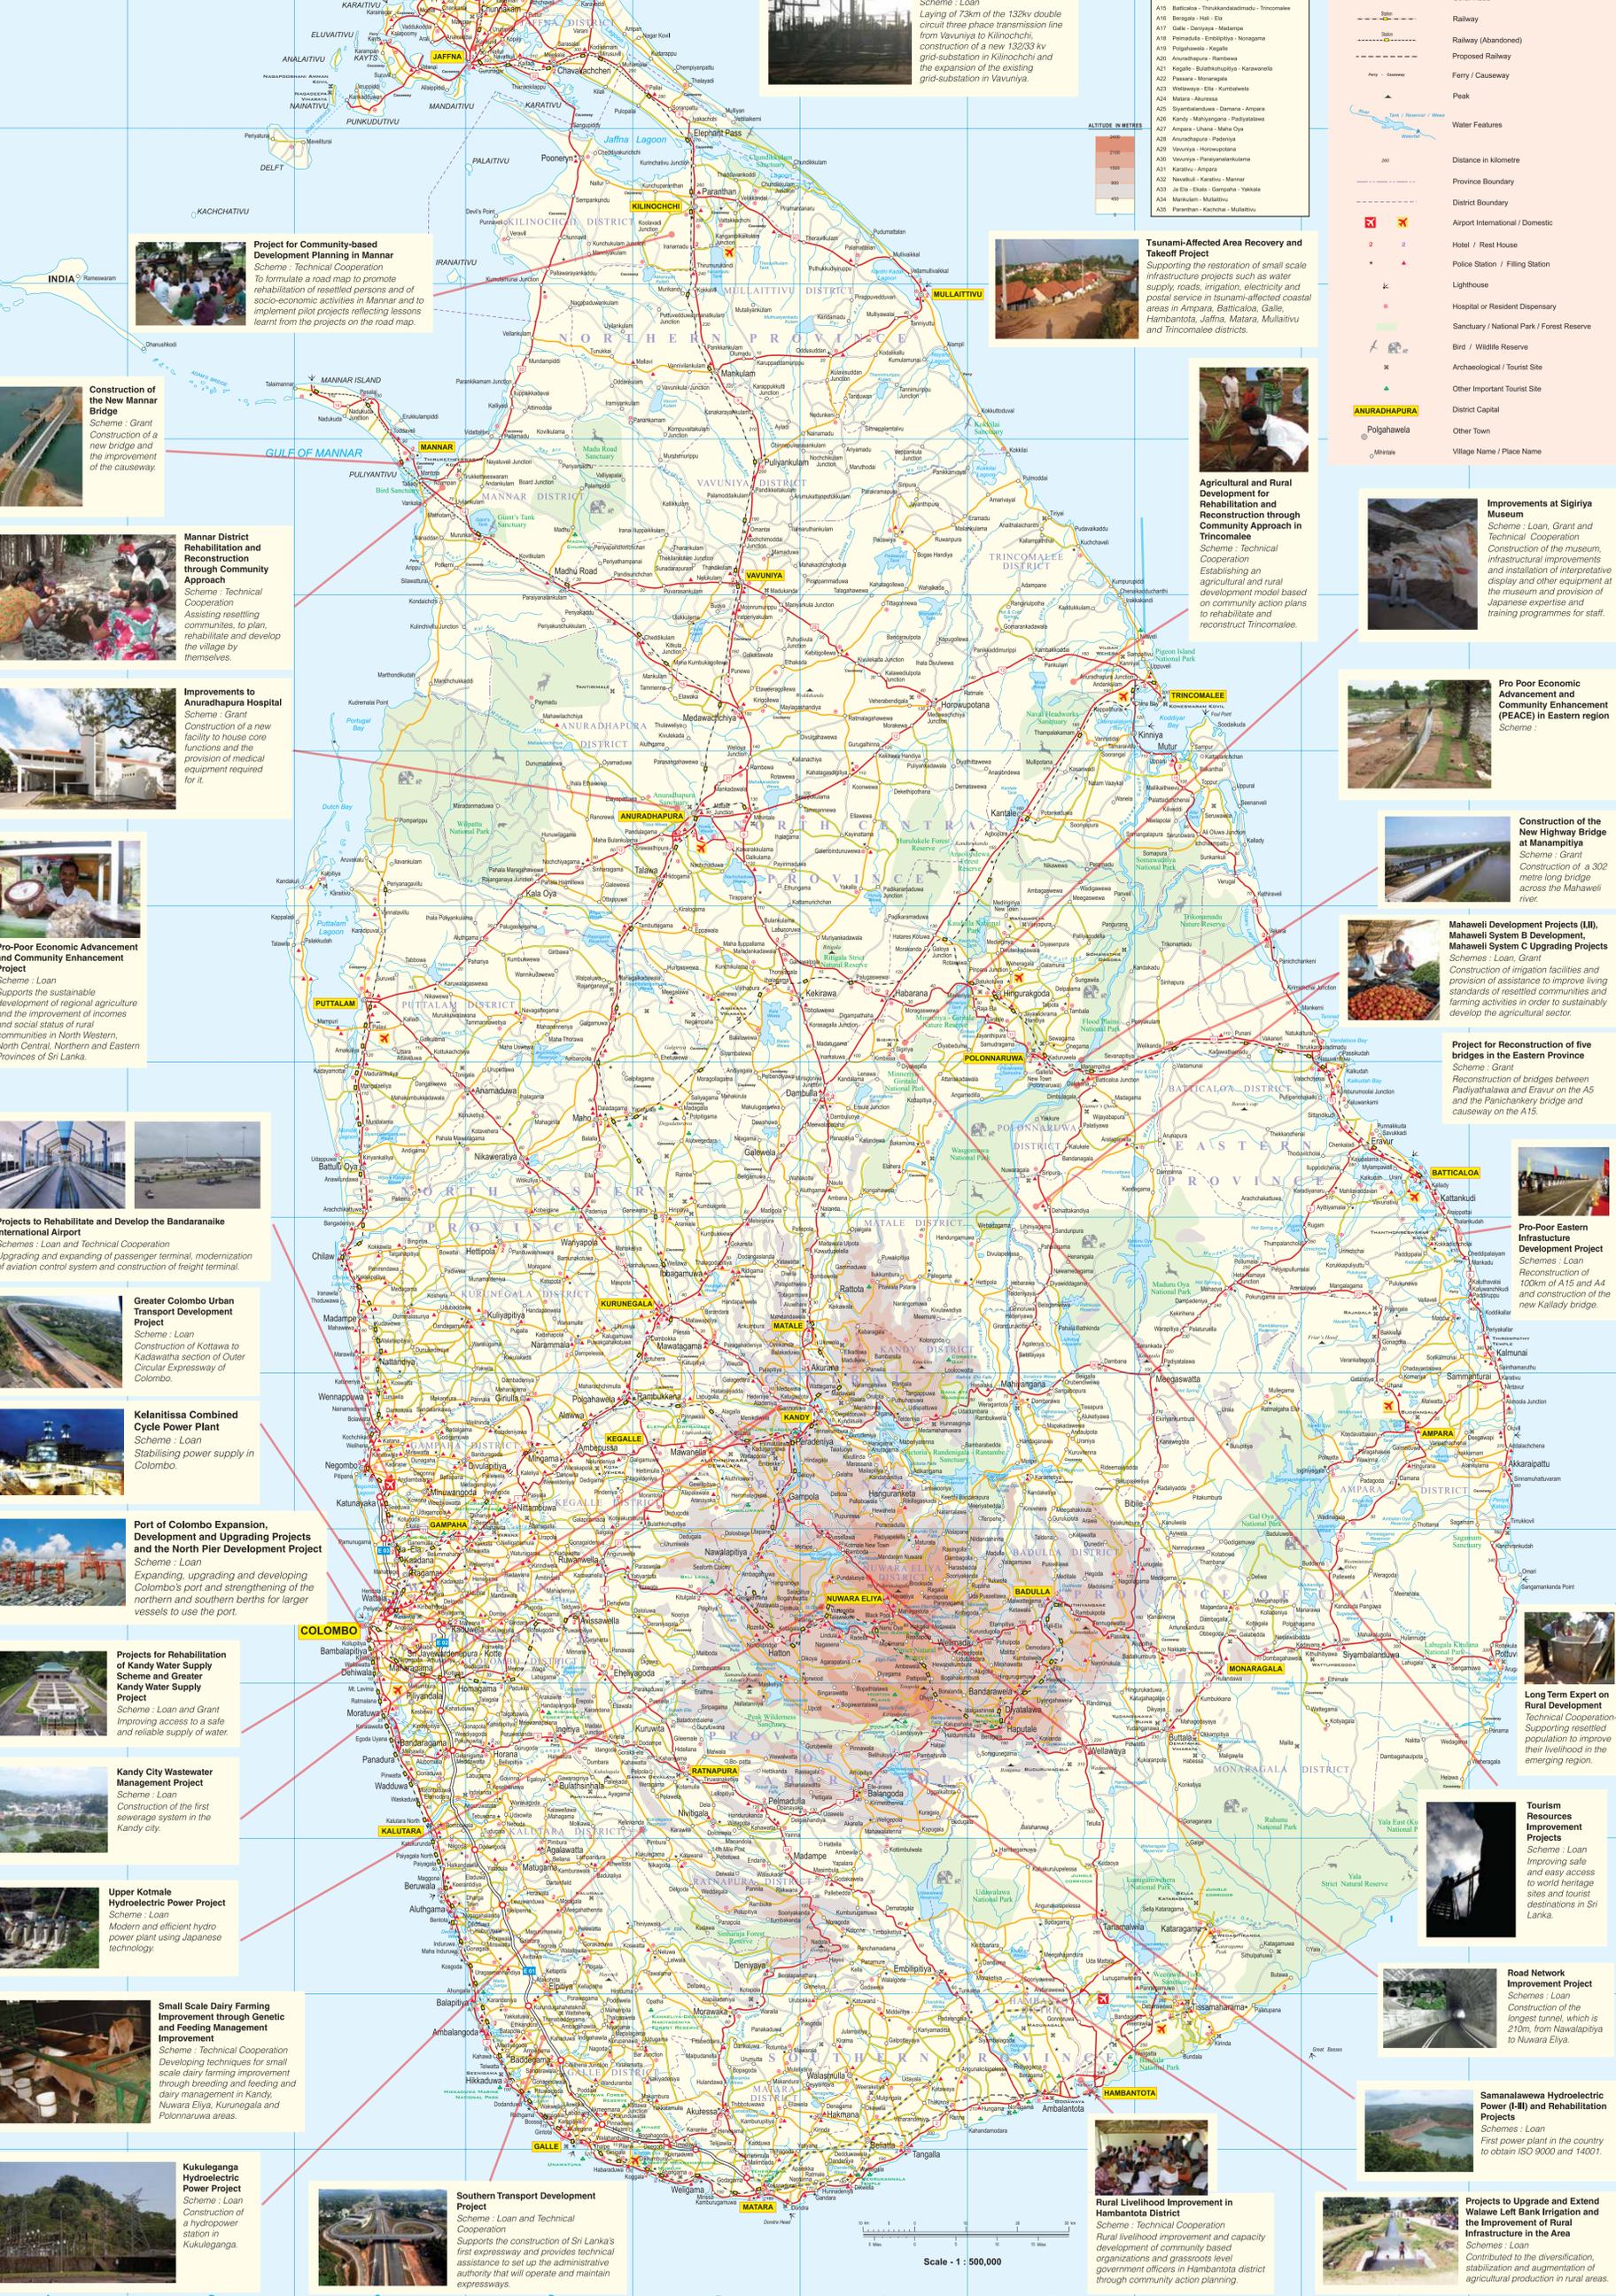

A - ROADS

A0	Kilinochchi - Sri Jayawardenapura-Kotte
A1	Colombo - Kandy
A2	Colombo - Galle - Hambantota - Welisara
A3	Polonnaruwa - Puttalam
A4	Colombo - Ratnapura - Welisara - Batticaloa
A5	Peradeniya - Badulla - Chenkaiwadi
A6	Ampara - Kurunegala - Trincomalee
A7	Akassella - Hattotuwa - Nuwara Eliya
A8	Panadura - Hambantota - Ratnapura
A9	Kandy - Jaffna
A10	Kilinochchi - Kurunegala - Puttalam
A11	Maradankadawala - Habarana - Thirukandamadu
A12	Puttalam - Trincomalee
A13	Wellisara - Eruva - Kumbalanga
A14	Medawachchya - Mannar - Talaimannar
A15	Batticaloa - Thirukandamadu - Trincomalee
A16	Batticaloa - Trincomalee - Trincomalee
A17	Galle - Deniyaya - Matlapa
A18	Peradeniya - Embilipitiya - Nuwara Eliya
A19	Polonnaruwa - Kandy
A20	Anuradhapura - Batticaloa
A21	Kogala - Bulankulugaha - Karawana
A22	Panadura - Moneragala
A23	Wellisara - Eruva - Kumbalanga
A24	Matara - Akassella
A25	Siyambalandura - Damana - Ampara
A26	Kandy - Mahiyangana - Padiyathalawa
A27	Anuradhapura - Uva - Mata Oya
A28	Anuradhapura - Padeniya
A29	Vavuniya - Horowpota
A30	Vavuniya - Padiyathalawa
A31	Kandy - Ampara
A32	Nuwara Eliya - Kandy - Mannar
A33	Ja-Ela - Hala - Gampaha - Yakkalamulla
A34	Matara - Matara - Yakkalamulla
A35	Panadura - Kandy - Matara

MAP REFERENCE

	Expressway
	Expressway (Under Construction)
	Proposed Road
	Main Road (A)
	Main Road (B)
	Secondary Road
	Other Road
	Railway
	Railway (Abandoned)
	Proposed Railway
	Ferry / Causeway
	Peak
	Water Features
	Distance in kilometre
	Province Boundary
	District Boundary
	Airport International / Domestic
	Hotel / Rest House
	Police Station / Filling Station
	Lighthouse
	Hospital or Resident Dispensary
	Sanctuary / National Park / Forest Reserve
	Bird / Wildlife Reserve
	Archaeological / Tourist Site
	Other Important Tourist Site
	District Capital
	Other Town
	Village Name / Place Name



Project for Community-based Development Planning in Mannar
Scheme : Technical Cooperation
To formulate a road map to promote rehabilitation of resettled persons and of socio-economic activities in Mannar and to implement pilot projects reflecting lessons learnt from the projects on the road map.



Construction of the New Mannar Bridge
Scheme : Grant
Construction of a new bridge and the improvement of the causeway.




Mannar District Rehabilitation and Reconstruction through Community Approach
Scheme : Technical Cooperation
Assisting resettling communities to plan, rehabilitate and develop the village by themselves.



Improvements to Anuradhapura Hospital
Scheme : Grant
Construction of a new facility to house core functions and the provision of medical equipment required for it.



Pro-Poor Economic Advancement and Community Enhancement Project
Scheme : Loan
Supports the sustainable development of regional agriculture and the improvement of incomes and social status of rural communities in North Western, North Central, Northern and Eastern Provinces of Sri Lanka.

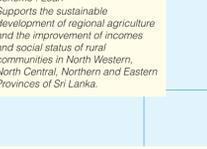

Projects to Rehabilitate and Develop the Bandaranaika International Airport
Schemes : Loan and Technical Cooperation
Upgrading and expanding of passenger terminal, modernization of aviation control system and construction of freight terminal.



Greater Colombo Urban Transport Development Project
Scheme : Loan
Construction of tollways to Kotte and the section of Outer Circular Expressway of Colombo.



Kalanitsa Combined Cycle Power Plant
Scheme : Loan
Stabilising power supply in Colombo.




Port of Colombo Expansion, Development and Upgrading Projects and the North Pier Development Project
Scheme : Loan
Expanding, upgrading and developing Colombo's port and strengthening of the northern and southern berths for larger vessels to use the port.



Projects for Rehabilitation of Kandy Water Supply Scheme and Greater Kandy Water Grant Project
Scheme : Loan and Grant
Improving access to a safe and reliable supply of water.



Kandy City Wastewater Management Project
Scheme : Loan
Construction of the first sewerage system in the Kandy city.

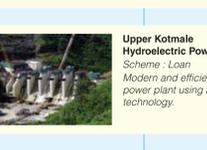

Upper Kotmale Hydroelectric Power Project
Scheme : Loan
Modern and efficient hydro power plant using Japanese technology.



Small Scale Dairy Farming Improvement through Genetic and Feeding Management Improvement
Scheme : Technical Cooperation
Developing techniques for small scale dairy farming improvement through breeding and feeding and daily management in Kandy, Nuwara Eliya, Kurunegala and Polonnaruwa areas.



Kukuleganga Hydroelectric Power Project
Scheme : Loan
Construction of a hydropower station in Kukuleganga.



Southern Transport Development Project
Scheme : Loan and Technical Cooperation
Supports the construction of Sri Lanka's first expressway and provides technical assistance to set up the administrative authority that will operate and maintain expressways.

Rural Livelihood Improvement in Hambantota District
Scheme : Technical Cooperation
Rural livelihood improvement and capacity development of community based organizations and grassroots level government officers in Hambantota district through community action planning.

Scale 1 : 500,000